

STEPHENSON MEMORIAL LIBRARY

GREENFIELD, NEW HAMPSHIRE

FOR CONSTRUCTION

FOUNDATION DRAIN IMPROVEMENTS

PREPARED BY

UNDERWOOD ENGINEERS
PORTSMOUTH, NEW HAMPSHIRE

October 21, 2016




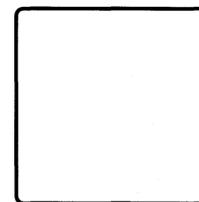


TABLE OF CONTENTS

SHEET TITLE	SHEET NO.
COVER SHEET	1
PROPOSED SITE PLAN	2
GENERAL NOTES & DETAILS	3

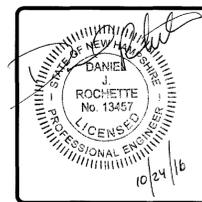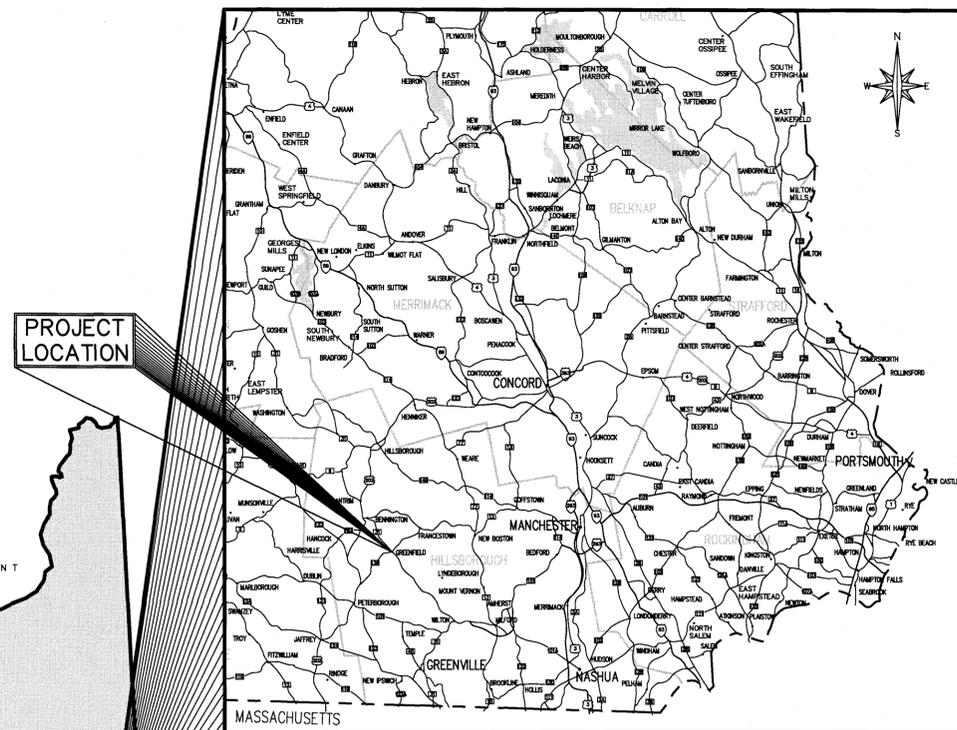


LOCATION PLAN

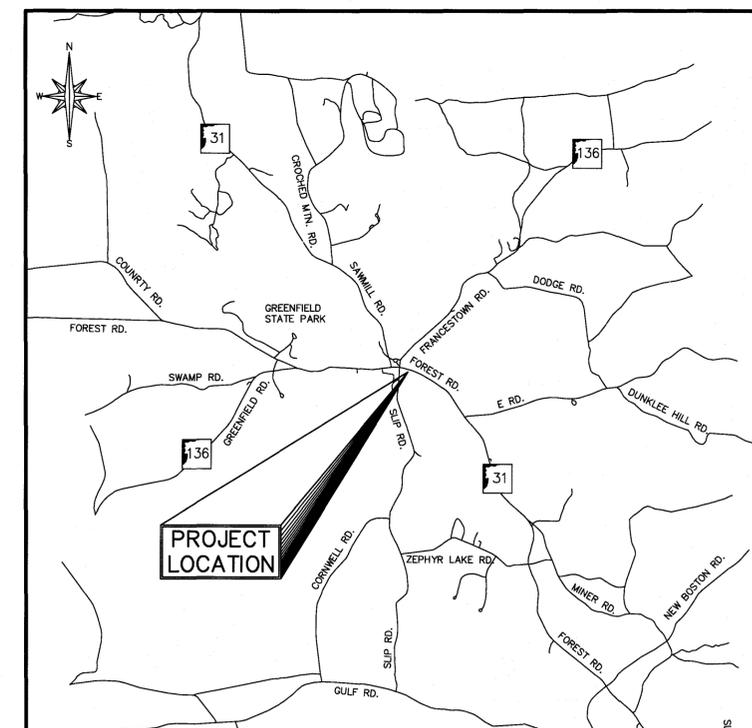

VICINITY MAP

UE #2058

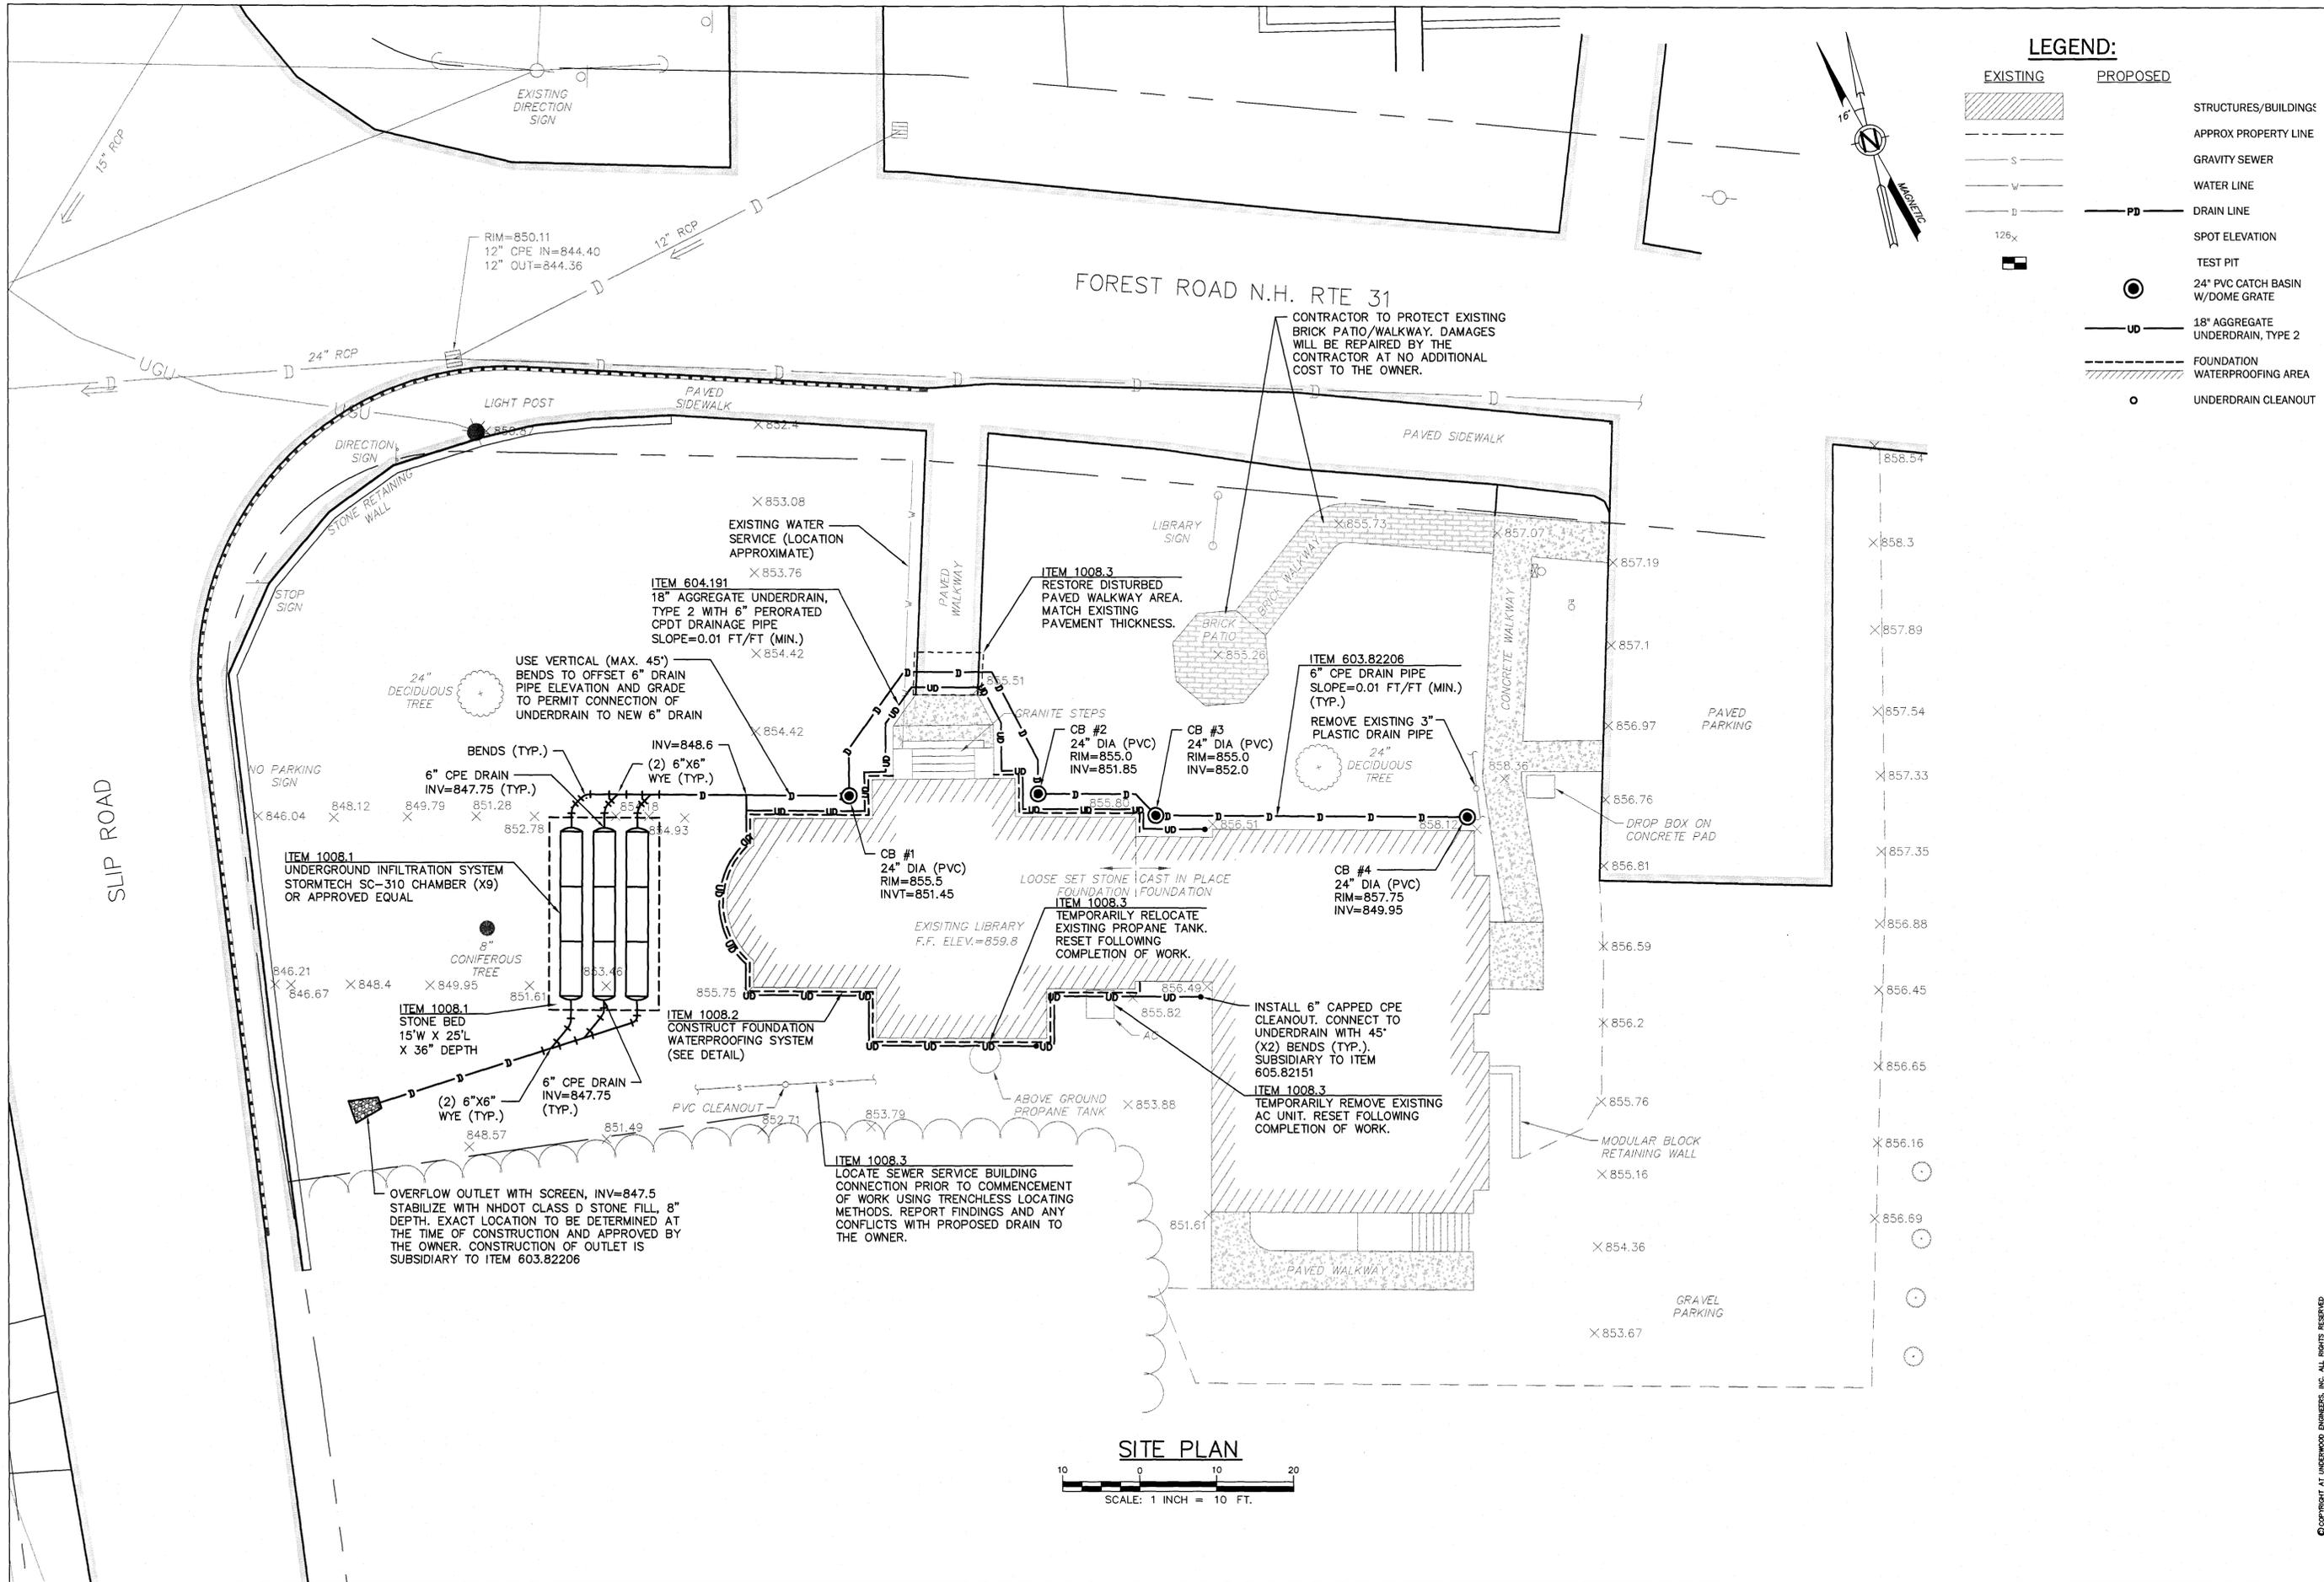

LEGEND:

- | | | | |
|--|----------------------------------|--|----------------------------------|
| | EXISTING | | PROPOSED |
| | STRUCTURES/BUILDINGS | | APPROX PROPERTY LINE |
| | GRAVITY SEWER | | WATER LINE |
| | WATER LINE | | DRAIN LINE |
| | DRAIN LINE | | SPOT ELEVATION |
| | SPOT ELEVATION | | TEST PIT |
| | TEST PIT | | 24" PVC CATCH BASIN W/DOME GRATE |
| | 18" AGGREGATE UNDERDRAIN, TYPE 2 | | FOUNDATION WATERPROOFING AREA |
| | FOUNDATION WATERPROOFING AREA | | UNDERDRAIN CLEANOUT |

ISSUE FOR	APPROVAL	DATE	BY
DESIGNED	DATE	BY	
CHECKED	DATE	BY	
APPROVED	DATE	BY	
CONSTRUCTION	DATE	BY	
RECORD DRAWING	DATE	BY	
REVISIONS	NO.	DATE	BY
APP'D			

Drawn/Chk. - MAH	10/21/16	Project No. 2058
Designed - DJR	10/21/16	Dwg. ID 2058_sskst
Checked - DJR	10/21/16	Scale AS SHOWN
Approved - DJR	10/21/16	

UNDERWOOD engineers
 25 Vaughan Mall, Portsmouth, N.H. 03801
 Tel. 603-436-6192 Fax. 603-431-4733

SITE PLAN
FOUNDATION DRAIN IMPROVEMENTS
STEPHENSON MEMORIAL LIBRARY
TOWN OF GREENFIELD
GREENFIELD, NEW HAMPSHIRE

SITE PLAN
 SCALE: 1 INCH = 10 FT.

